


PLAN VIEW

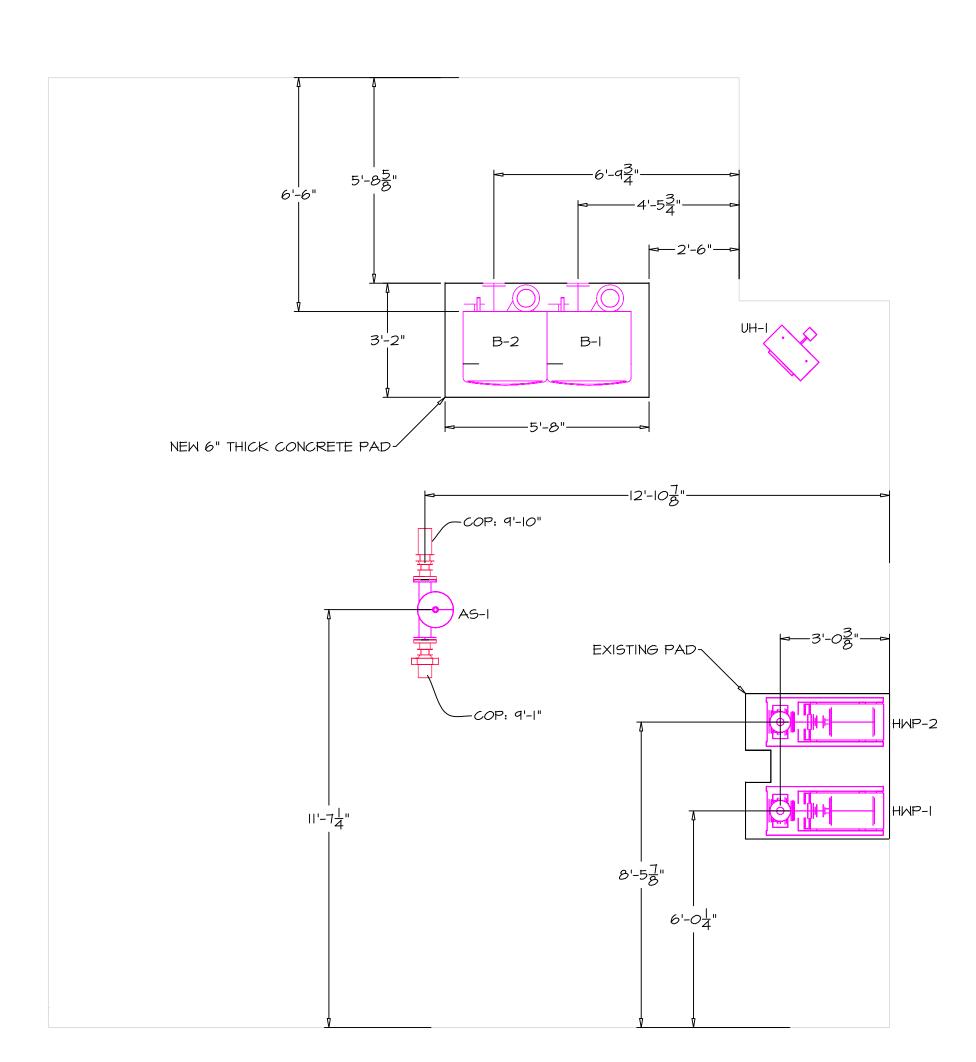


EQUIPMENT & PAD LAYOUT

-INSULATION NOT SHOWN FOR CLARITY.


-INSULATION TO BE 2" THICK ON HWS/R AND I" THICK ON MU WATER

-REFER TO EQUIPMENT LAYOUT DWG "EQ-MR-AW" FOR EXACT EQUIPMENT LAYOUT.

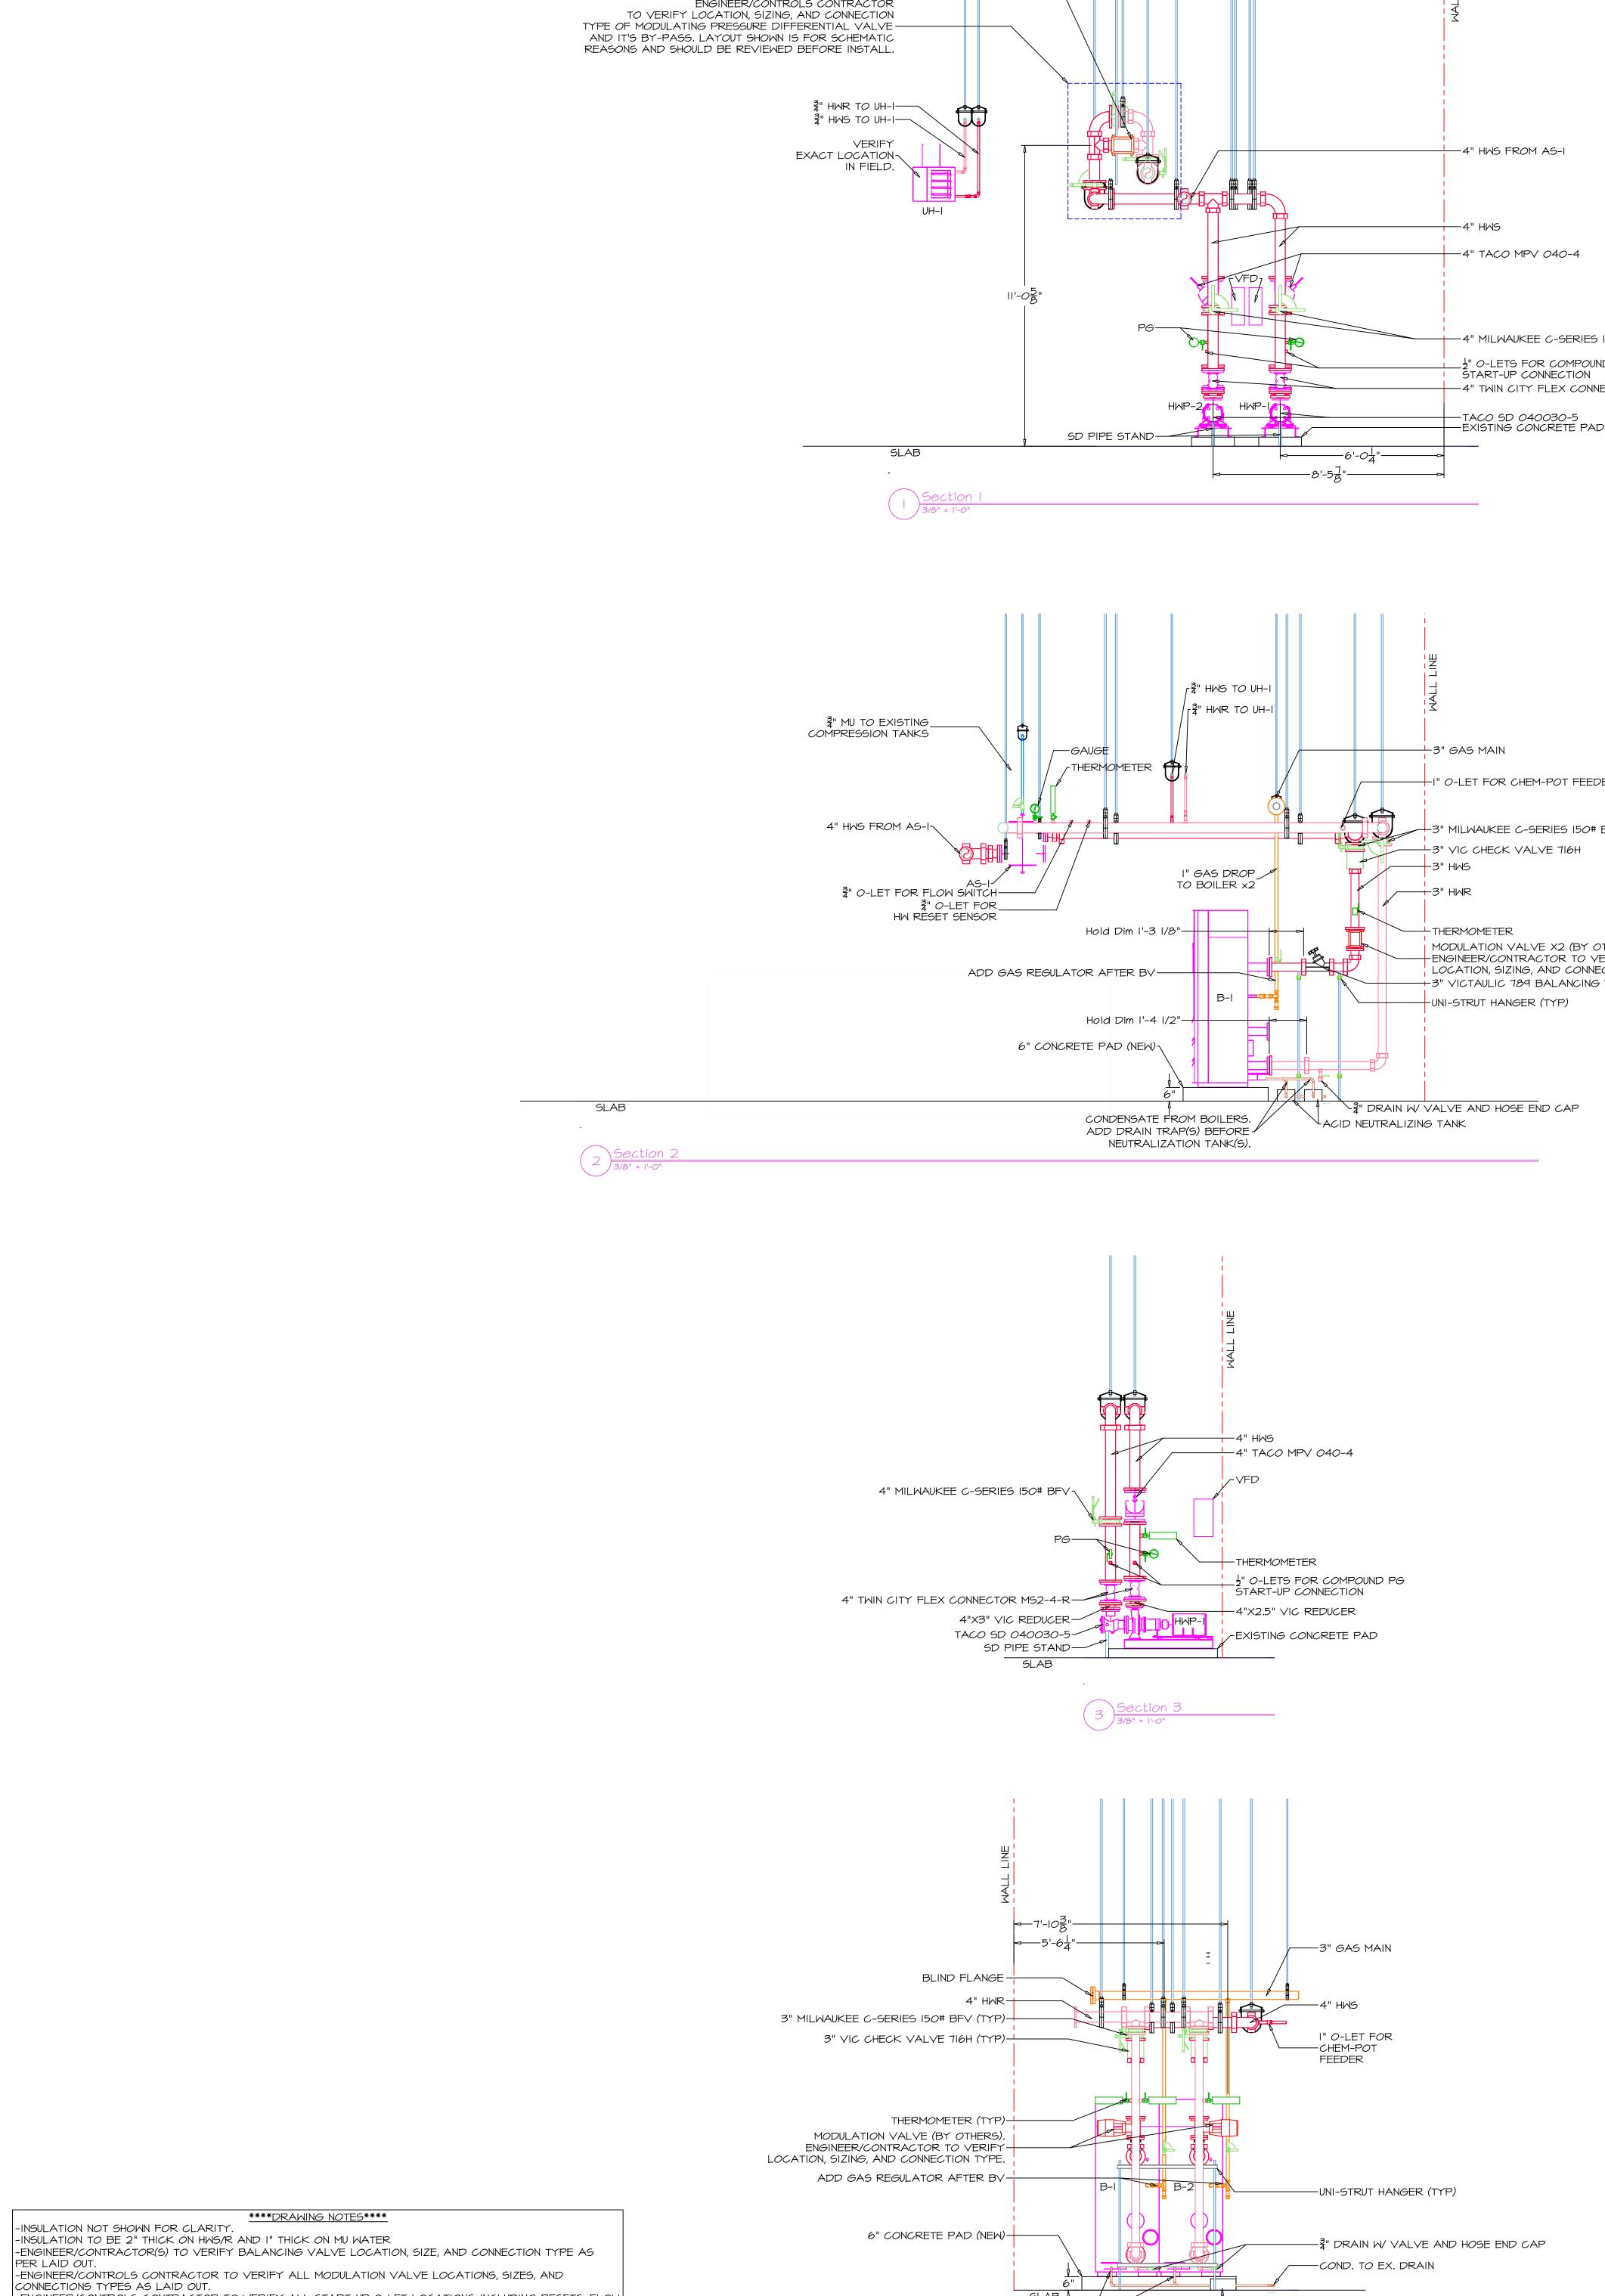

PRESSURE DIFFERENTIAL MODULATING VALVE (BY OTHERS).

SEE NOTE BELOW

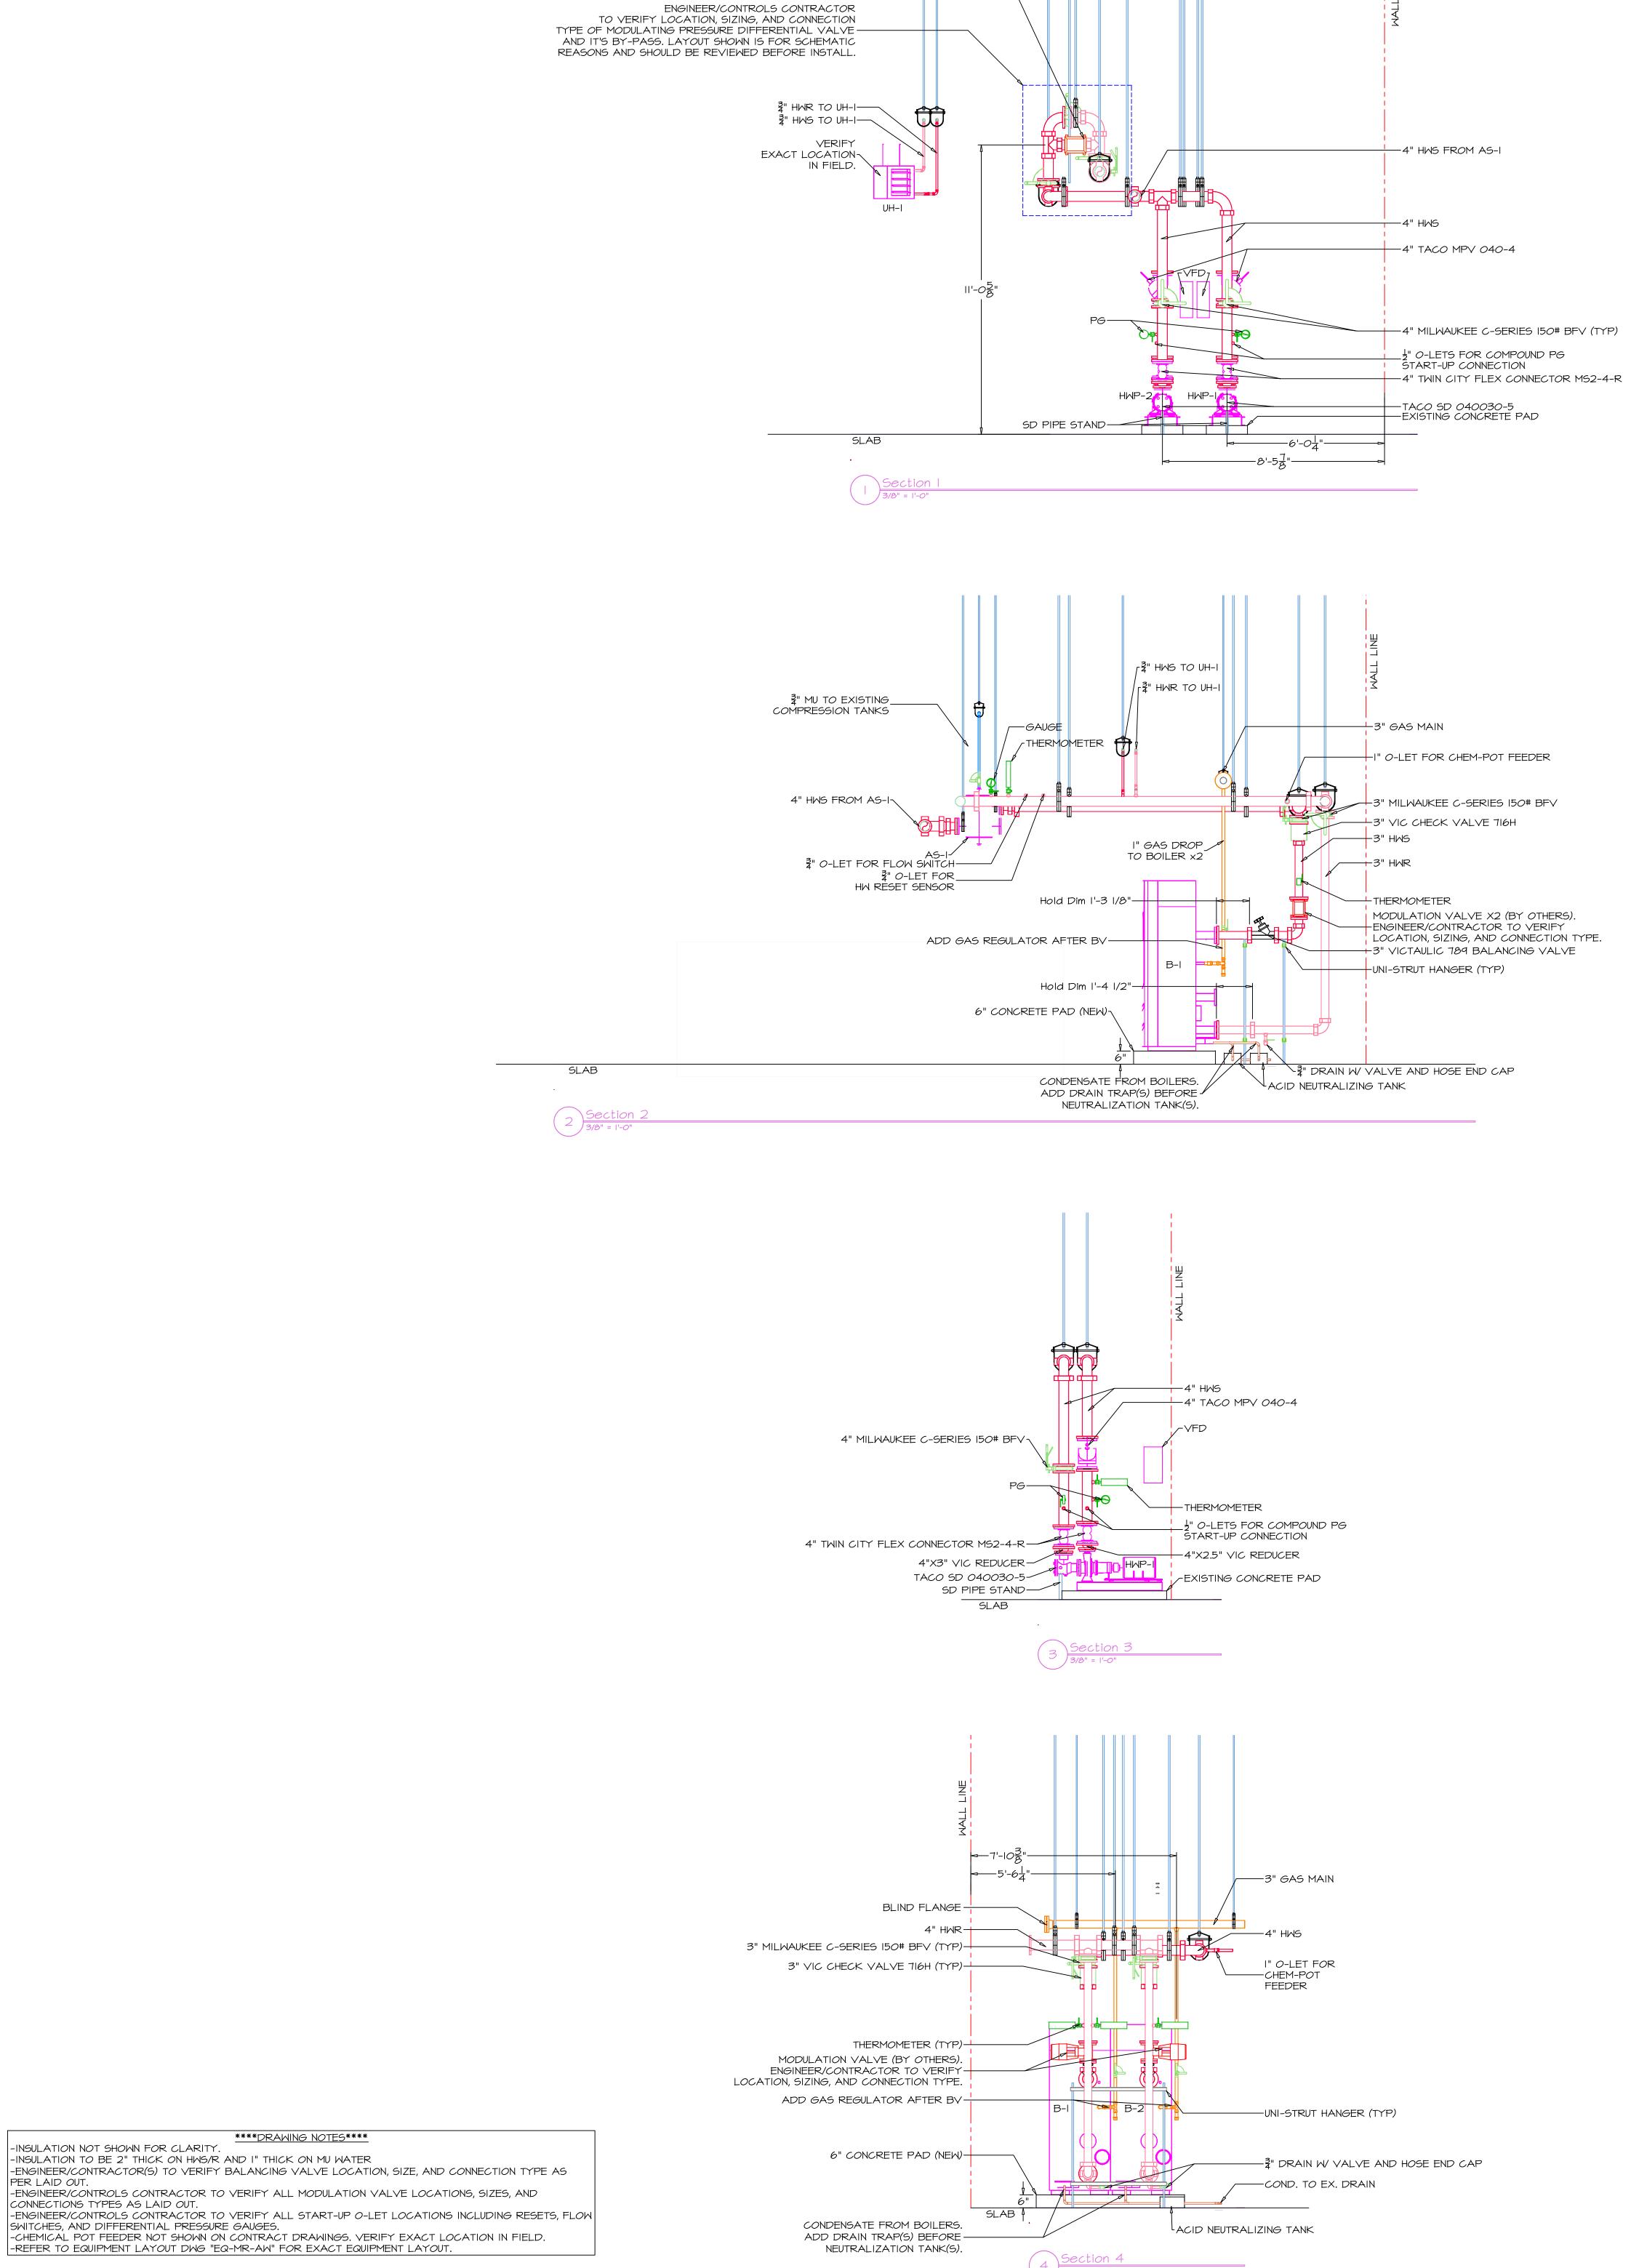

3/8"=1'-0" PM PM

AUDREY W CLARK

ROOM PIPING LAYOUT

M-100-AW

SCHOOL MECHANICAL